


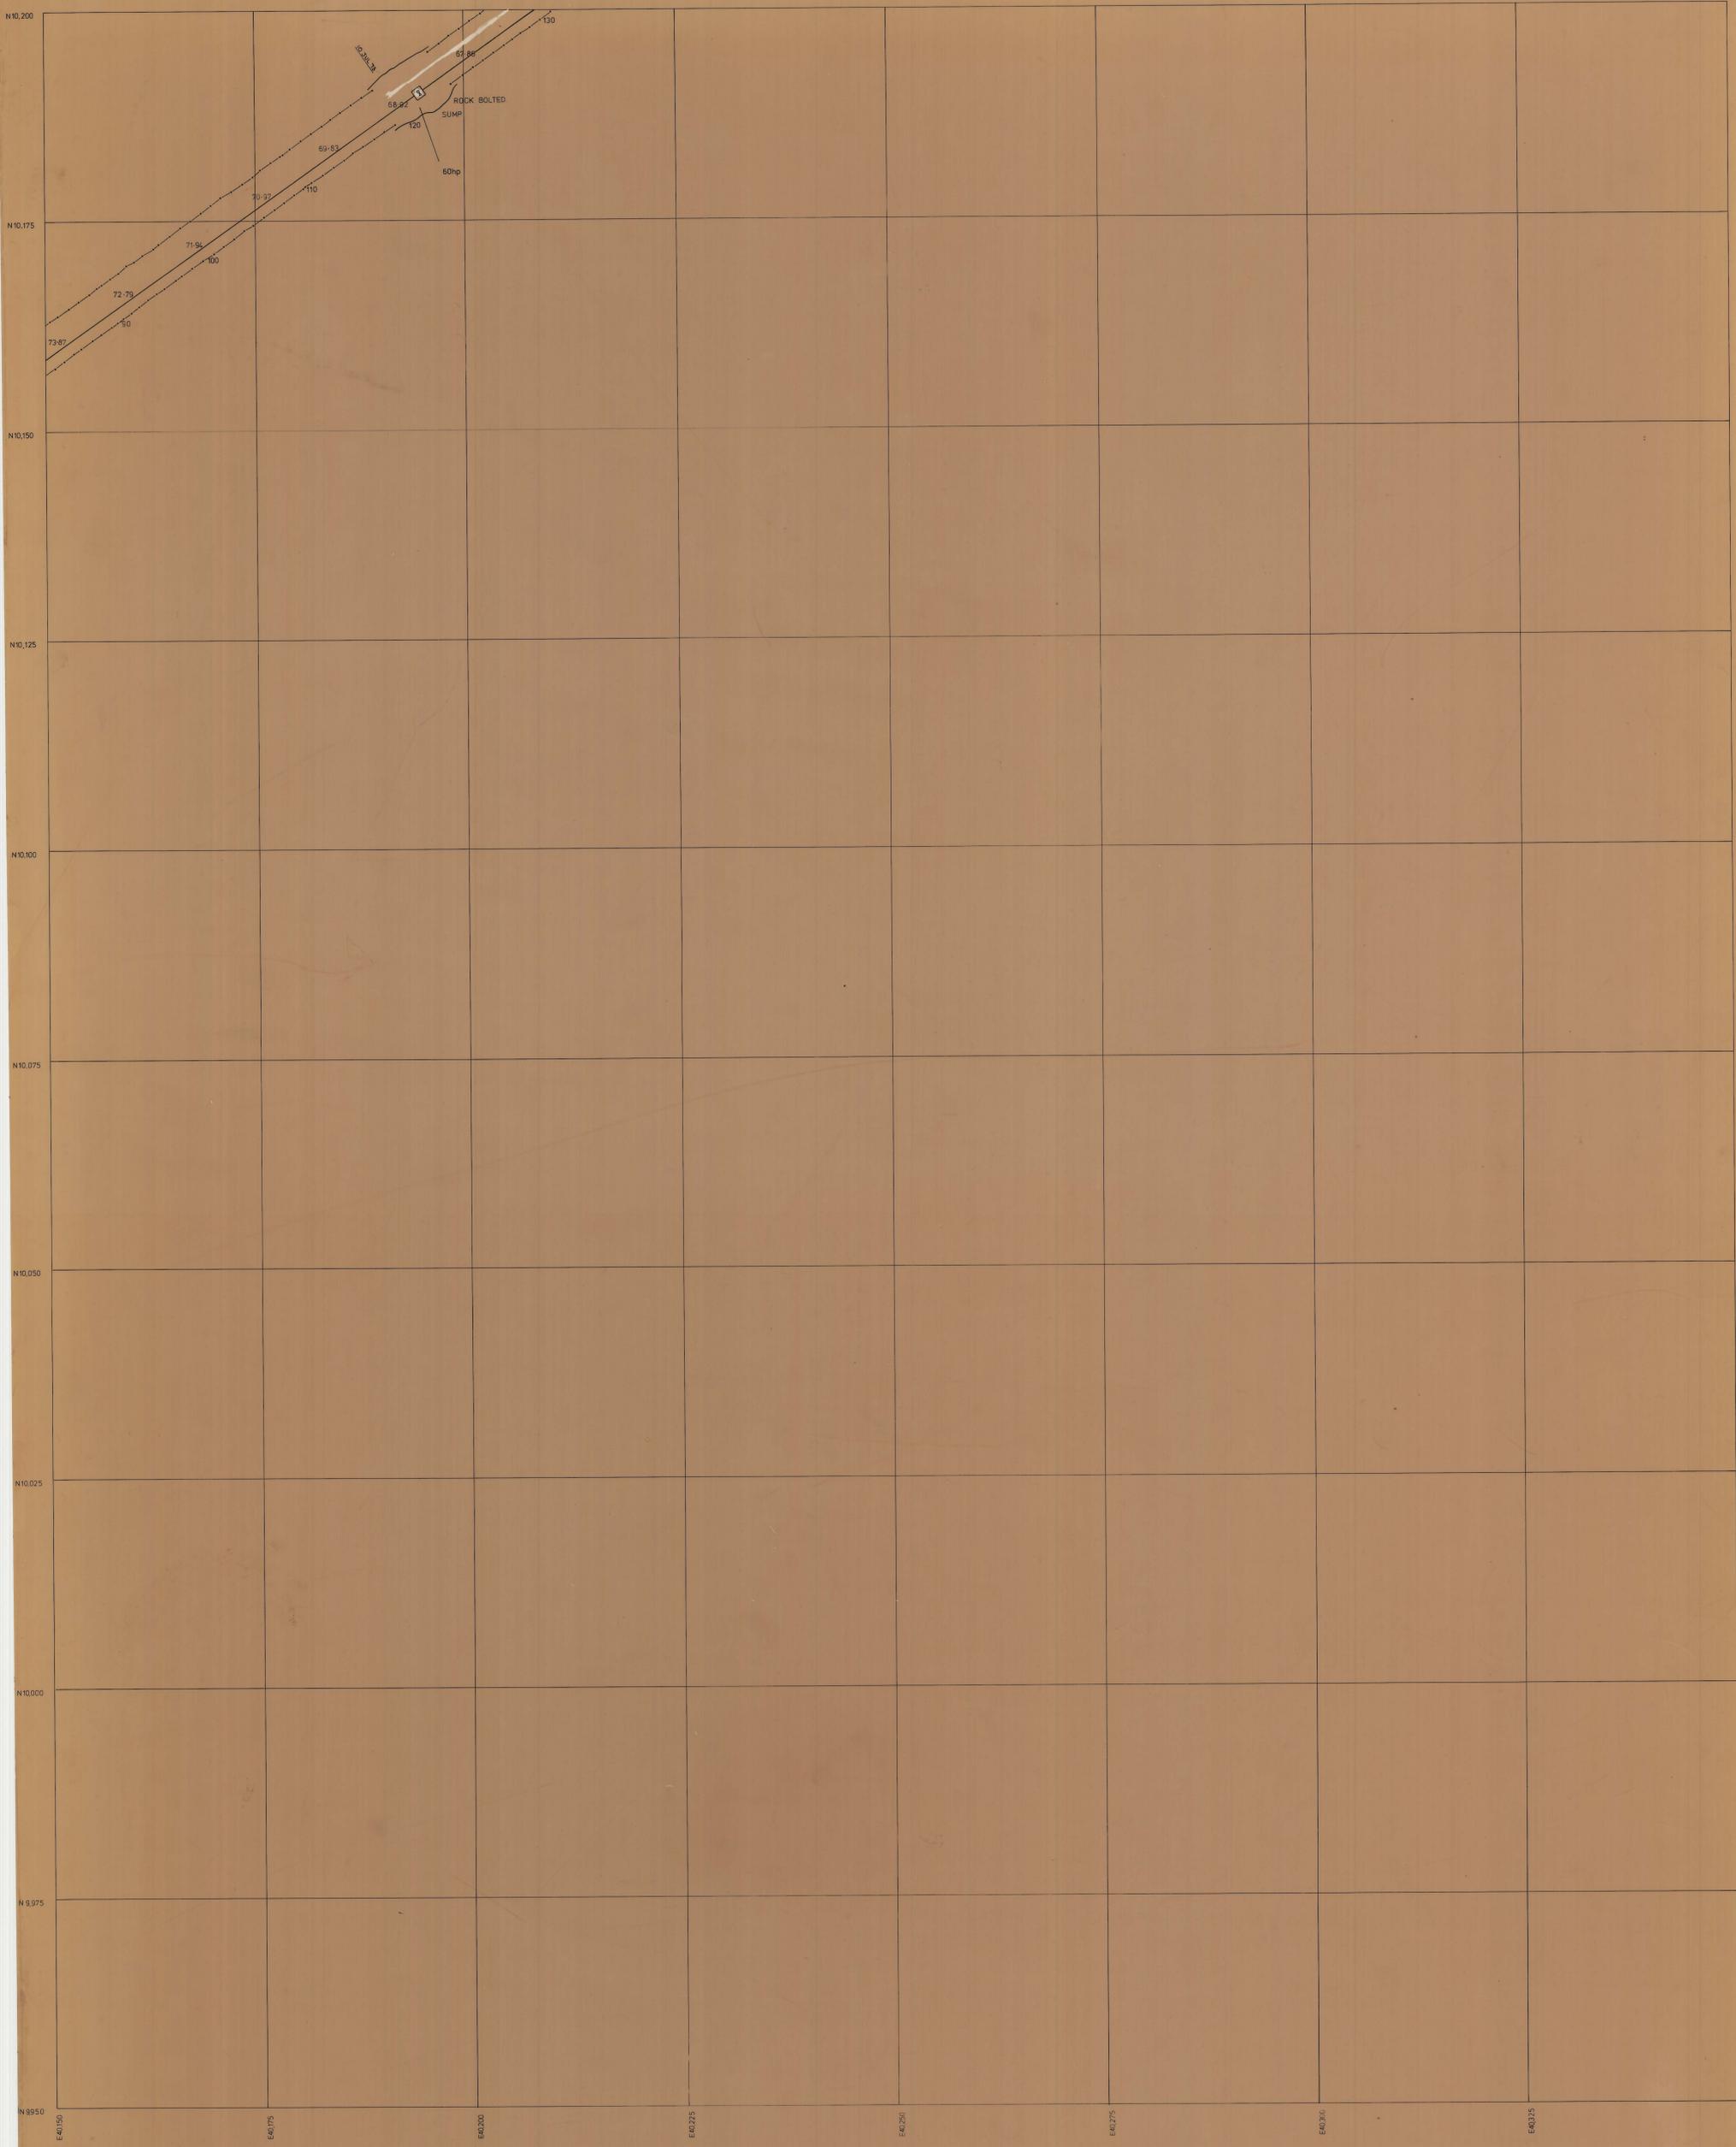

0374_3503

1:250
BOLD HEAD MINE
VENTILATION PLAN
1-5-73



KING ISLAND SCHEELITE LTD.

BOLD HEAD MINE.
VENTILATION
SCALE 1:250

