



0374\_3609

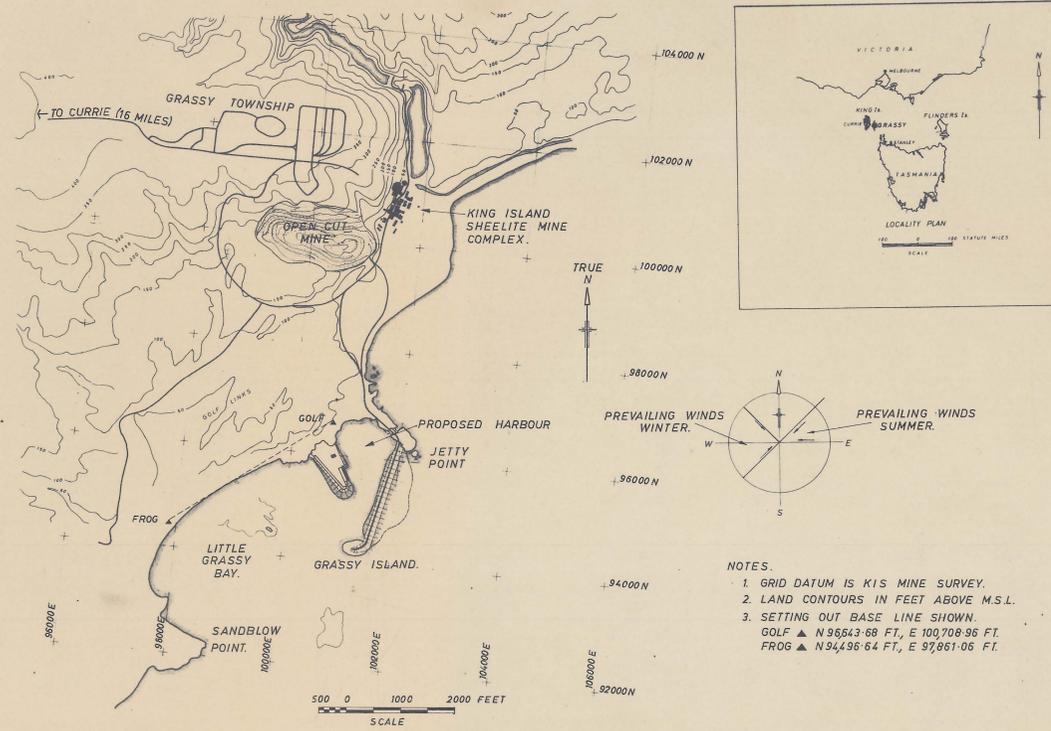

SITE PLAN

- NOTES.
1. GRID DATUM IS KIS MINE SURVEY.
  2. LAND CONTOURS IN FEET ABOVE M.S.L.
  3. SETTING OUT BASE LINE SHOWN.
- GOLF ▲ N95643.68 FT, E 100708.96 FT.  
 FROG ▲ N94496.64 FT, E 97861.06 FT.

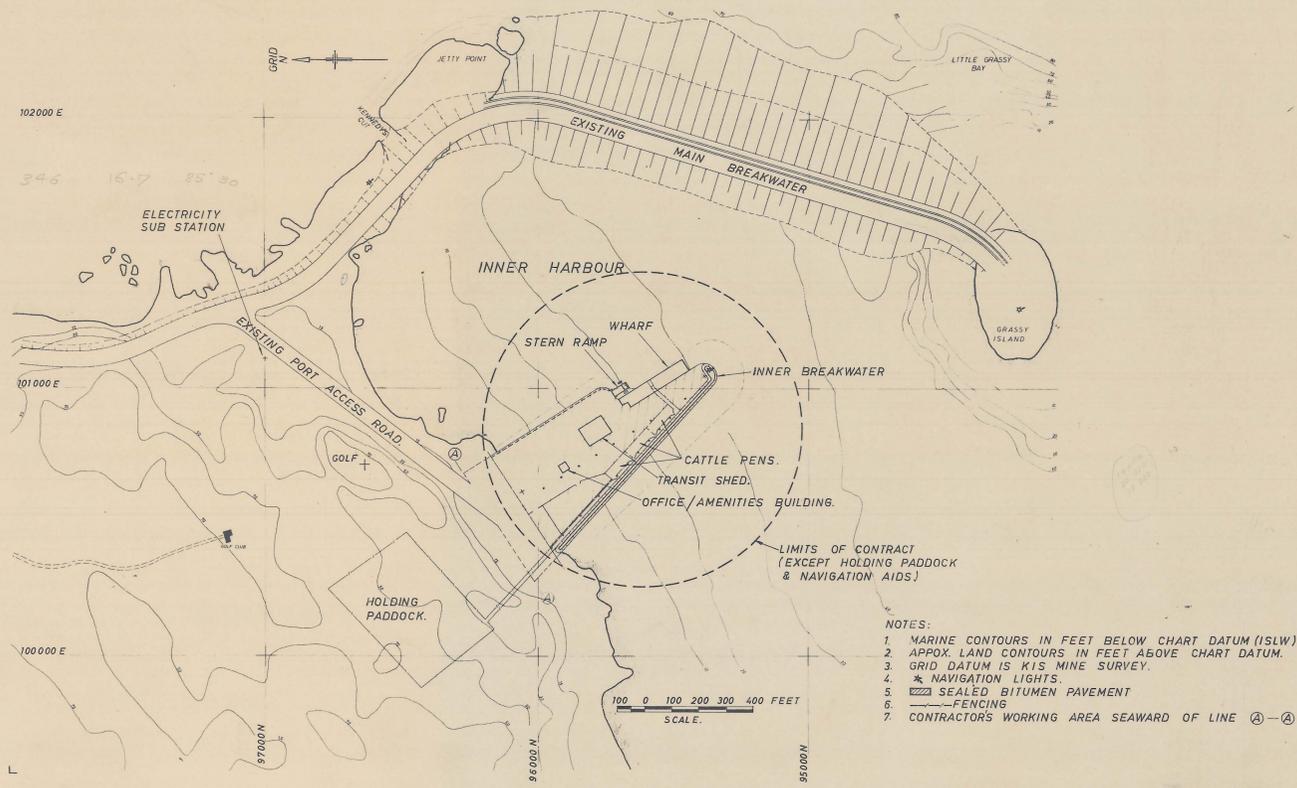

HARBOUR PLAN.

- NOTES:
1. MARINE CONTOURS IN FEET BELOW CHART DATUM (ISLW)
  2. APPROX. LAND CONTOURS IN FEET ABOVE CHART DATUM.
  3. GRID DATUM IS KIS MINE SURVEY.
  4. \* NAVIGATION LIGHTS
  5. [Symbol] SEALED BITUMEN PAVEMENT
  6. [Symbol] FENCING
  7. CONTRACTOR'S WORKING AREA SEAWARD OF LINE (A)-(A)

DRAWING REFERENCE	
DRG N <sup>o</sup>	TITLE
2070 / 101	GENERAL SITE PLAN
102	PORT AREA - GENERAL DEVELOPMENT.
103	RECLAMATION AND PAVEMENT DETAILS.
104	DRAINAGE AND GRADING DETAILS.
105	FENCING AND BARRIERS
106	NAVIGATION AIDS
WHARF	
2070 / 201	GENERAL ARRANGEMENT OF WHARF, AND DETAILS OF CRANE, CATTLE RAMP AND STERN RAMP.
202	PILE SETTING OUT AND DETAILS
203	GENERAL ARRANGEMENT.
204	G.A. AND REINFORCEMENT DETAILS - PRECAST UNITS.
205	G.A. AND REINFORCEMENT DETAILS - INSITU CROSSHEAD SHEET 1.
206	G.A. AND REINFORCEMENT DETAILS - INSITU CROSSHEAD SHEET 2.
207	INSITU DECK REINFORCING SHEET 1.
208	INSITU DECK REINFORCING SHEET 2.
209	G.A. RAMP ABUTMENT AND GANTRY PILE CAPS
210	G.A. RAMP ABUTMENT AND GANTRY PILE CAPS - REINFORCING DETAILS.
211	STERN FENDER DETAILS.
212	WHARF FENDERS - KERBS BOLLARD
213	CATTLE RAMP DETAILS.
RAMP	
2070 / 301	G.A. RAMP AND GANTRY
302	STEELWORK - DETAIL OF RAMP
303	STEELWORK - LINK SPAN AND LEVELLING FLAPS.
304	STEELWORK GANTRY DETAILS SHEET 1.
305	STEELWORK GANTRY DETAILS SHEET 2.
306	STEELWORK LIFTING BEAM AND LOCKING MECHANISM.
307	DETAILS OF LOCKING RACK AND COUNTER WEIGHT.
308	MISCELLANEOUS DETAILS.
309	DETAILS OF SLIDING BEARING UNDER MAIN GIRDERS.
310	MECHANICAL AND ELECTRICAL SERVICES.
CARGO SHED	
2070 / 401	GENERAL ARRANGEMENT.
402	CLADDING DETAILS.
403	STEELWORK - PLANS AND ELEVATIONS.
404	STEELWORK - SECTIONS.
405	STEELWORK - DETAILS.
406	STEELWORK - MAIN DOOR DETAILS.
407	MISCELLANEOUS DETAILS.
408	FLOOR SLAB AND FOUNDATIONS.
OFFICE AND AMENITIES BUILDING	
2070 / 501	GENERAL ARRANGEMENT.
SERVICES	
2070 / 601	ELECTRICAL LAYOUT.
602	SWITCHBOARD LAYOUT AND WIRING DIAGRAM.
603	CARGO SHED OFFICE AMENITIES ELEC. INSTALLATION.
604	WATER SUPPLY AND SEWERAGE RETICULATION.

GENERAL NOTES :

TENDER DRAWING ONLY  
NOT FOR CONSTRUCTION USE

REV. DATE DESCRIPTION  
KING ISLAND SCHEELITE LTD  
PORT AT LITTLE GRASSY BAY

GENERAL SITE PLAN

MAUNSELL & PARTNERS PTY. LTD.  
CONSULTING ENGINEERS

SCALE: AS SHOWN.  
DATE: FEB 1971  
DATE OF ISSUE: 16 APR 1971  
DRG. No. 2070/101  
S.C.  
N.W.  
K.A.B.