



LONGITUDINAL SECTION - DECANT PIPE

SCALES 1:1000 H
1:10 V

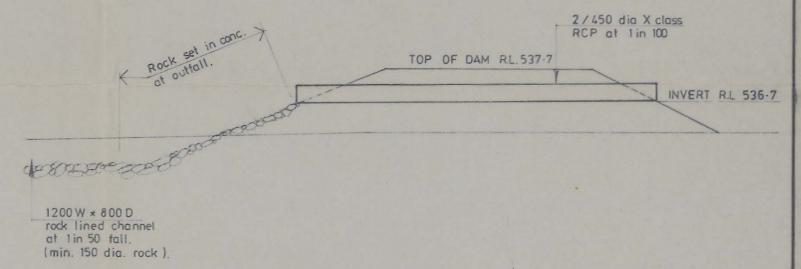

DETAIL AT SPILLWAY PIPE

 SCALE 1:100



CONTOURS SHOWN THUS ARE APPROX. ONLY.

SMITH SALE & BURBURY
CONSULTING STRUCTURAL & CIVIL ENGINEERS
295 MACQUARIE STREET, HOBART 7000 PHONE 23 6599
22 CAMERON STREET, LAUNCESTON 7250 PHONE 31 8655
24 NORTH TERRACE, BURNIE 7320 PHONE 31 5131

PROJECT NO. 8441 SHEET 1 OF 1

DRAWING TITLE: **SITE PLAN & DETAILS**

DATE: 26.3.1984 DRAWN BY: J.C. CHECKED BY: J. Meege

LETTER 26-3-84 F. 517-5-3

0402_044

0008/0018